



superior
electrical advertising

1700 West Anaheim Street
Long Beach, California
90813-1195
Phone: 562.495.3808
Facsimile: 562.435.1867
www.superiorsigns.com

SAFEWAY

Project:
Safeway
Store # 676

Address:
1500 Solano Ave.
Albany, CA 94706

Account Manager:
Tim Pitts

Designer:
Claudio Fuentes 3.50

Scale: **AS NOTED**

Design No.: **15-02-8838-05**

Date: **02.05.15**

Reg. No.:

Revisions:
R1 02-26-15 m dm (1.5) add info
R2 03-30-15 KF (4.0) add info, square footage and signs C & D
R03 JV 03/31/15 (1.50) add sign calculations
R04 JV 04/01/15 (1.50) resize Sign A; add Sign D options
R05 JV 04/07/15 (1.00) revert Sign A to 45"; Option 3 for Sign D

• APPROVALS •

FOR JOB CHECK DATE

Acct. Mgr.

FOR CONSTRUCTION DATE

Acct. Mgr.

Design

Production

FOR INSTALL ONLY DATE

Acct. Mgr.


Page: 01 Of: 12

This is an original unpublished drawing created by Superior Electrical Advertising, Inc. It is submitted for your approval. It is not to be shown to anyone outside of your organization, nor is it to be reproduced, copied or exhibited in any fashion. The changing of colors, sizes, materials or illumination method does not alter the design. Ownership of this design is held by Superior Electrical Advertising, Inc. Authorization to use this design in any fashion must be obtained in writing from Superior Electrical Advertising, Inc.

© SEA 2015

Note: The Colors depicted here are a graphic representation. Actual colors may vary. See color specifications.


SAFEWAY # 676-1500 SOLANO AVENUE, ALBANY, CA 94706

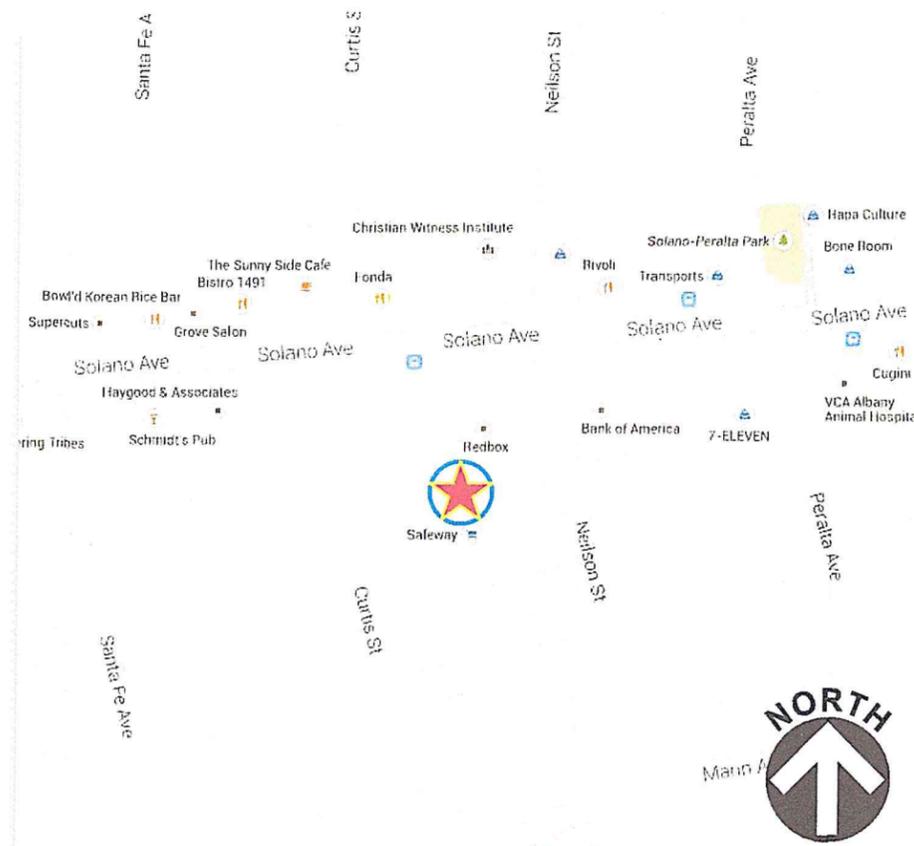

1 VICINITY MAP
SCALE: NTS

SIGN CHART (BUILDING SIGNS)					
	EXISTING	SQ FT	PROPOSED	SQ FT	TOTAL
SIGN A	4'-0" x 30'-0"	120.0	5'-0" x 28'-7"	142.92	
SIGN C	5'-2" x 6'-4"	37.2	4'-0" x 4'-4 3/8"	17.43	
SIGN D			2'-0" x 14'-6"	31.68	192.03
STOREFRONT				204'-8"	

NEILSON STREET

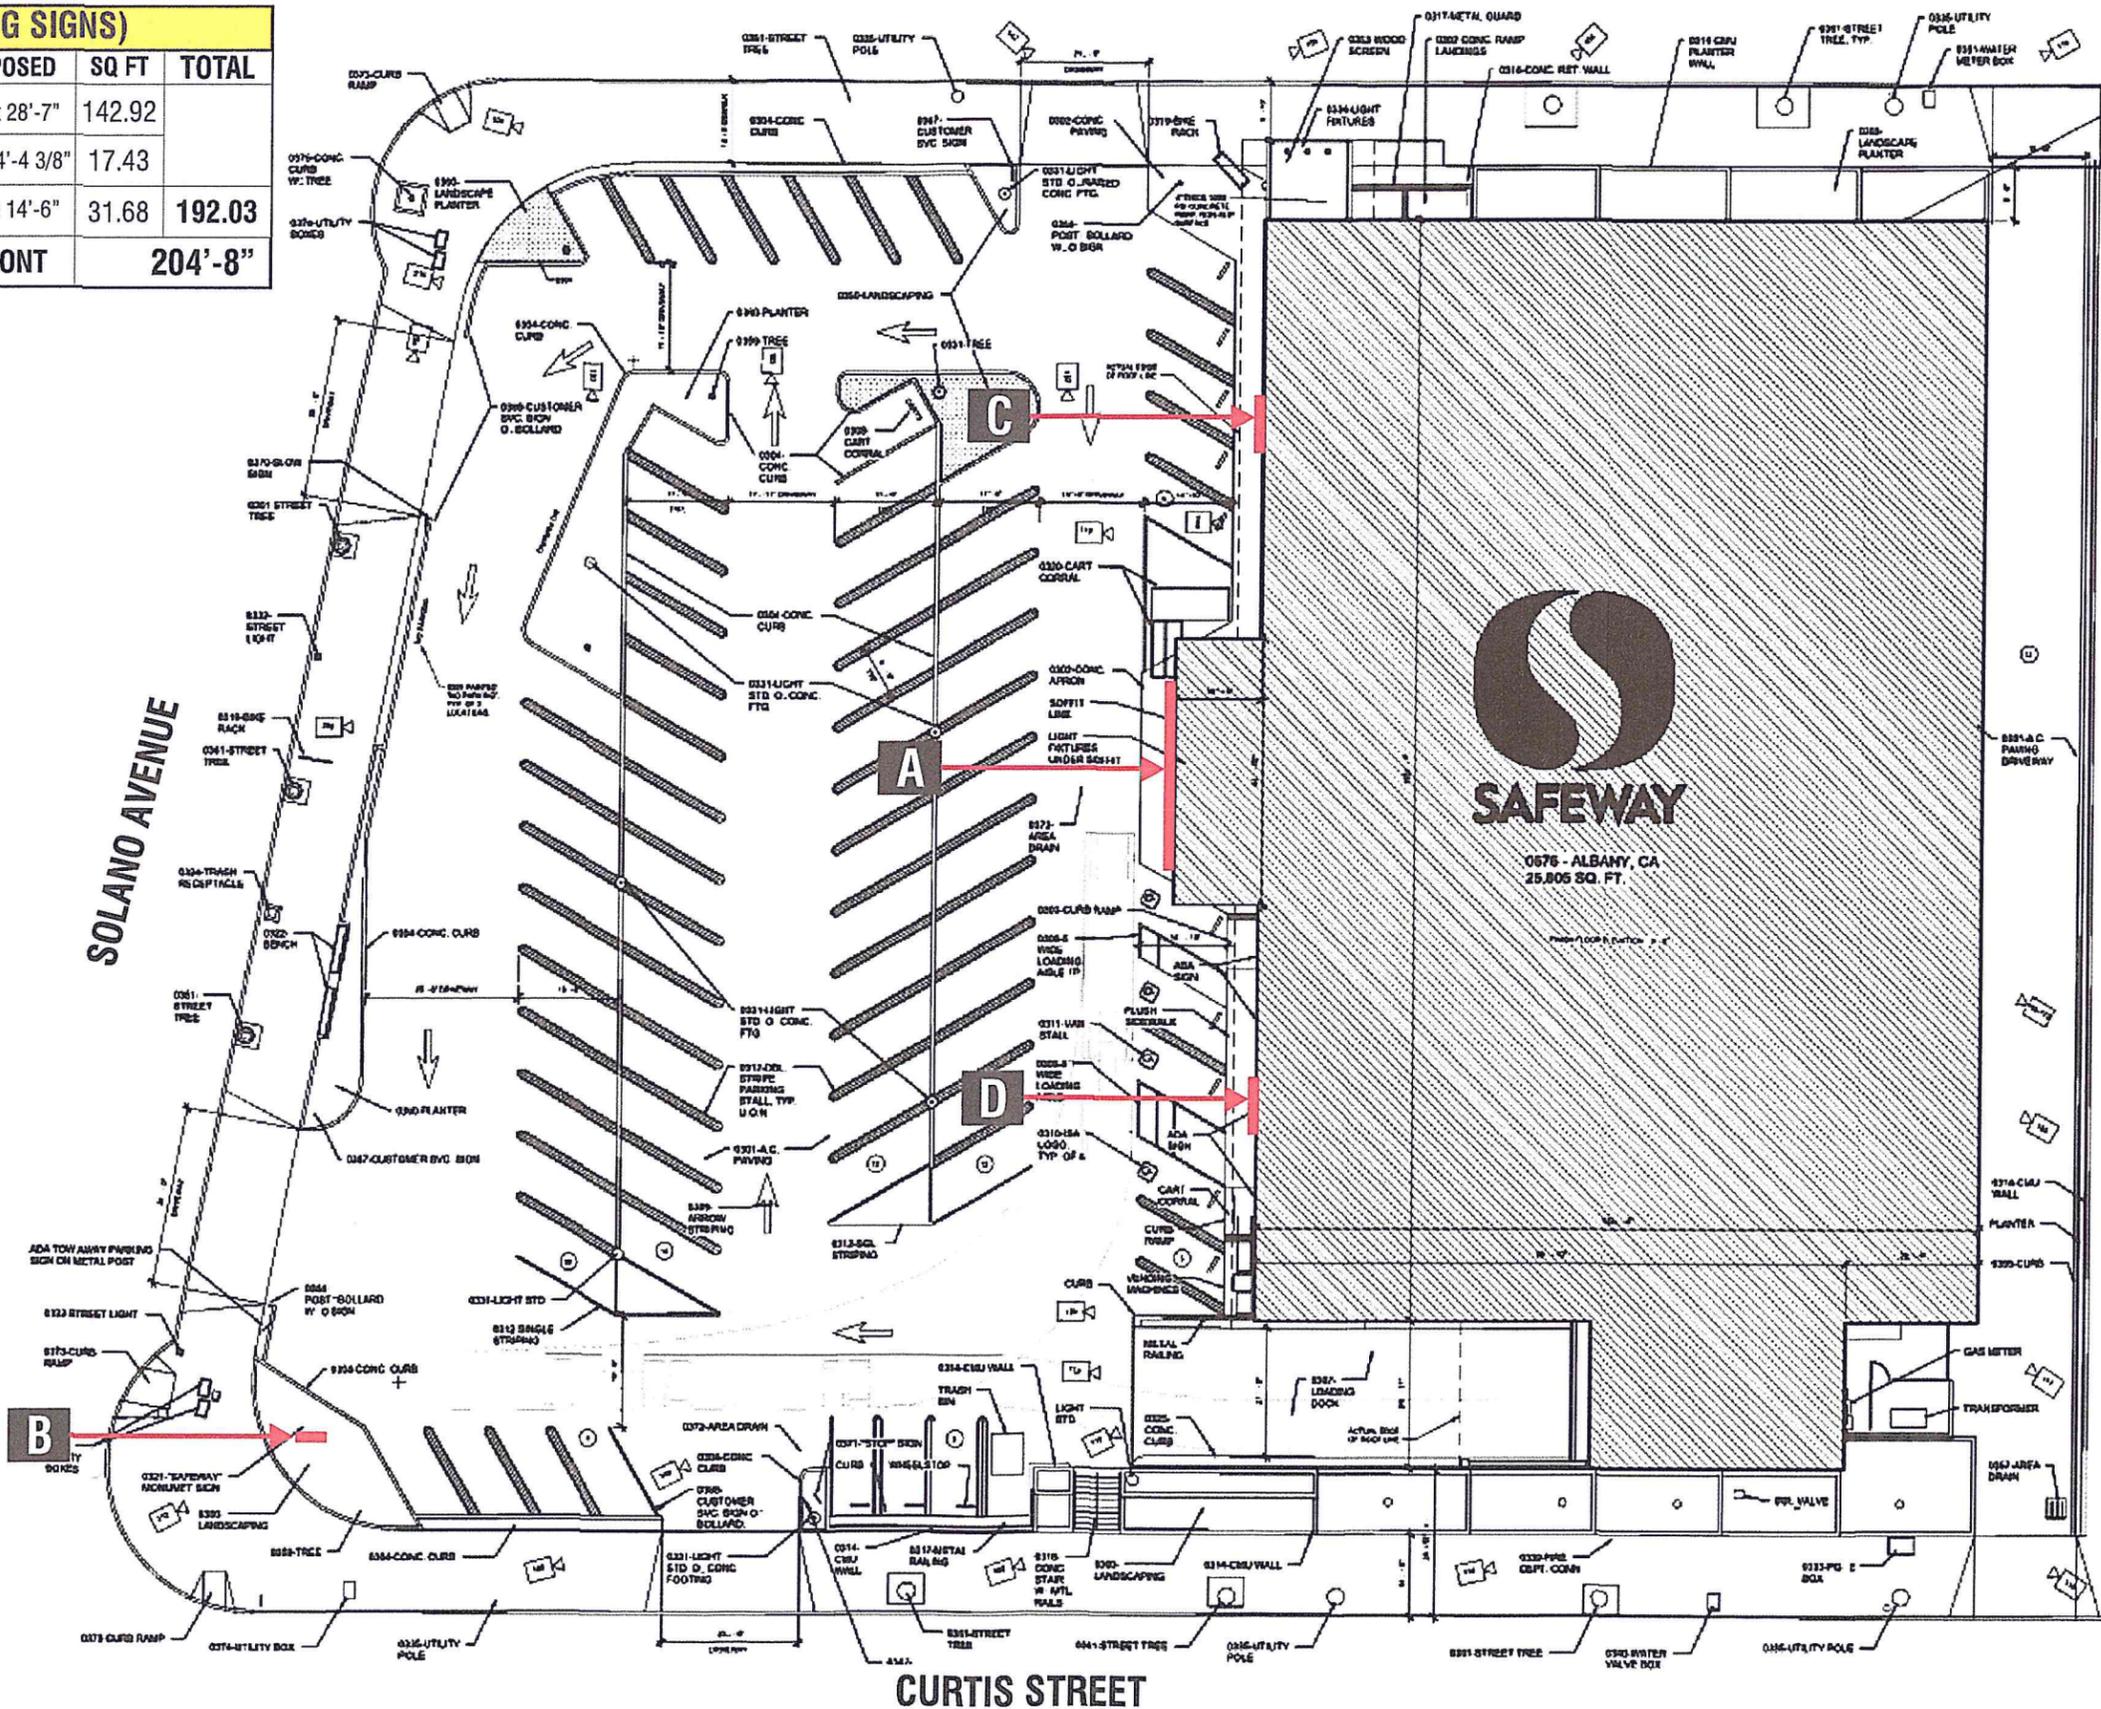

1 PLOT PLAN
SCALE: NTS

superior
electrical advertising

1700 West Anaheim Street
Long Beach, California
90813-1195
Phone: 562.495.3808
Facsimile: 562.435.1867
www.superiorsigns.com

Project:
Safeway
Store # 676

Address:
1500 Solano Ave.
Albany, CA 94706

Account Manager:
Tim Pitts

Designer:
Claudio Fuentes 3.50

Scale: **AS NOTED**

Design No.: **15-02-8838-05**

Date: **02.05.15**

Reg. No.:

Revisions:
R1 02-26-15 mdm (1.5) add info
R2 03-30-15 KF (4.0) add info, square footage and signs C & D
R3 JV 03/31/15 (1.50) add sign calculations
R04 JV 04/01/15 (1.50) resize Sign A; add Sign D options
R05 JV 04/07/15 (1.00) revert Sign A to 45"; Option 3 for Sign D

APPROVALS

FOR JOB CHECK DATE

Acct. Mgr.

FOR CONSTRUCTION DATE

Acct. Mgr.

Design

Production


FOR INSTALL ONLY DATE

Acct. Mgr.


Page: 02 Of: 12

This is an original unpublished drawing created by Superior Electrical Advertising, Inc. It is submitted for your approval. It is not to be reproduced, copied or exhibited in any fashion. The changing of colors, sizes, materials or illumination method does not alter the design. Ownership of this design is held by Superior Electrical Advertising, Inc. Authorization to use this design in any fashion must be obtained in writing from Superior Electrical Advertising, Inc. © SEA 2015

Note: The Colors depicted here are a graphic representation. Actual colors may vary. See color specifications.

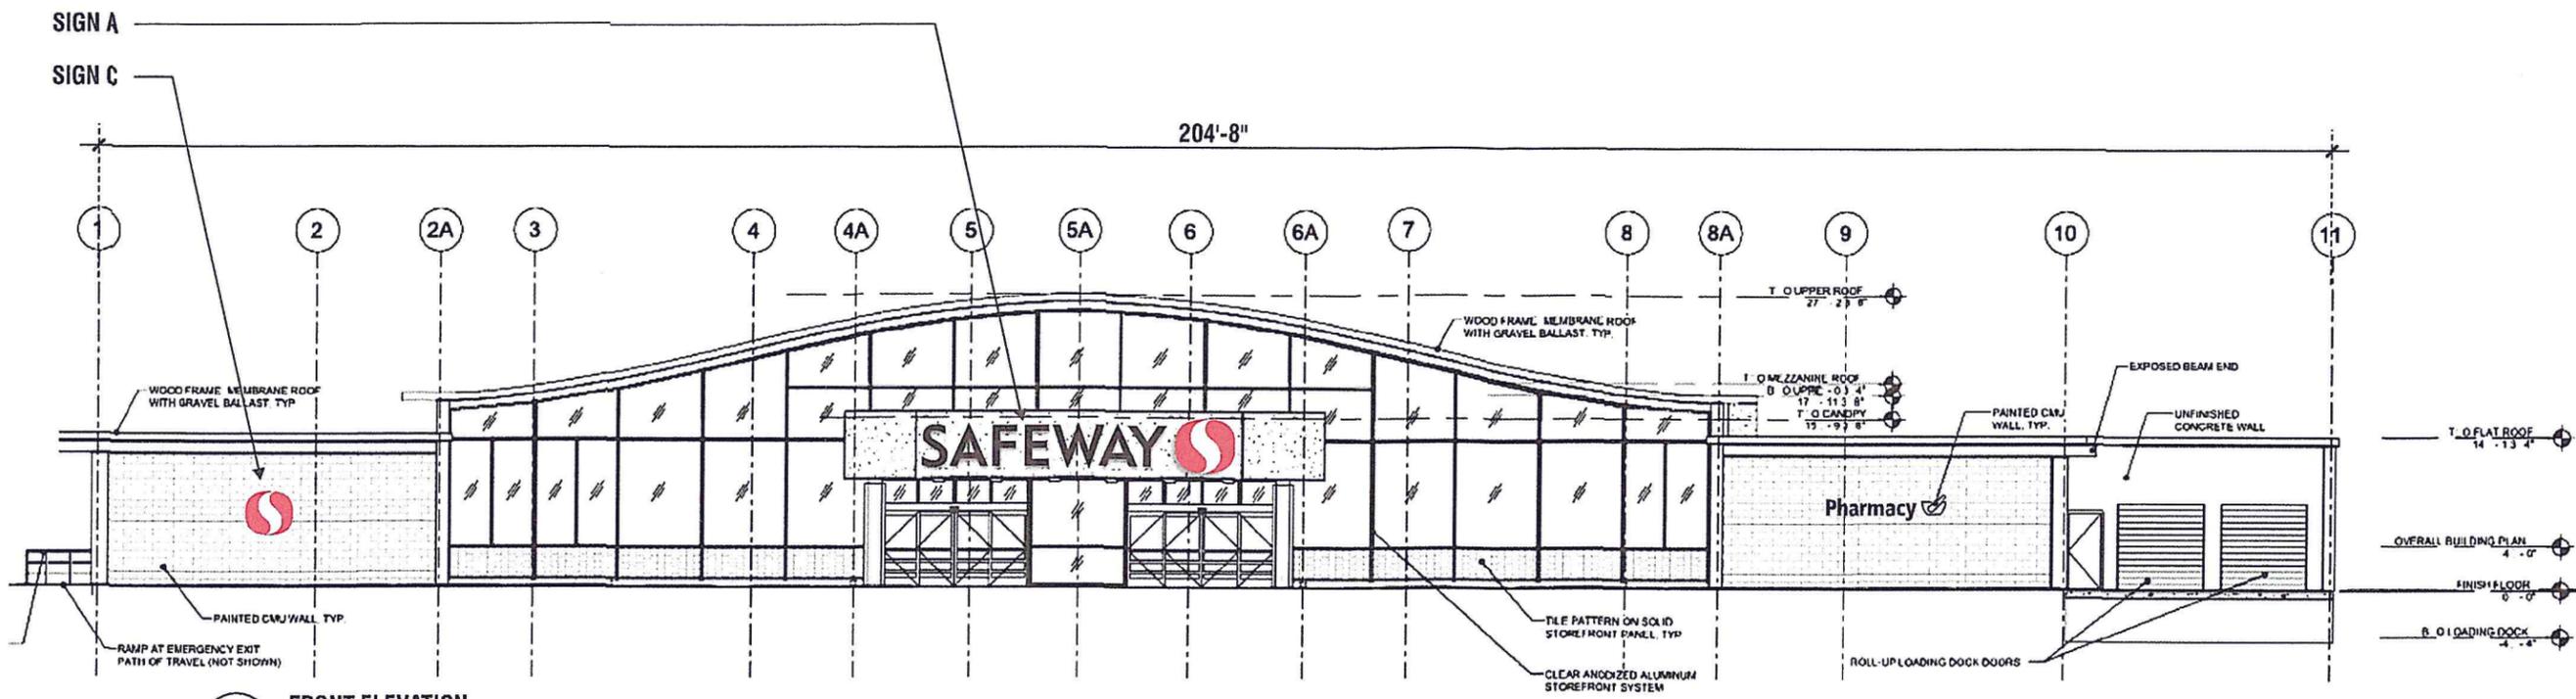

1 FRONT ELEVATION
SCALE: 1/16" = 1'-0"

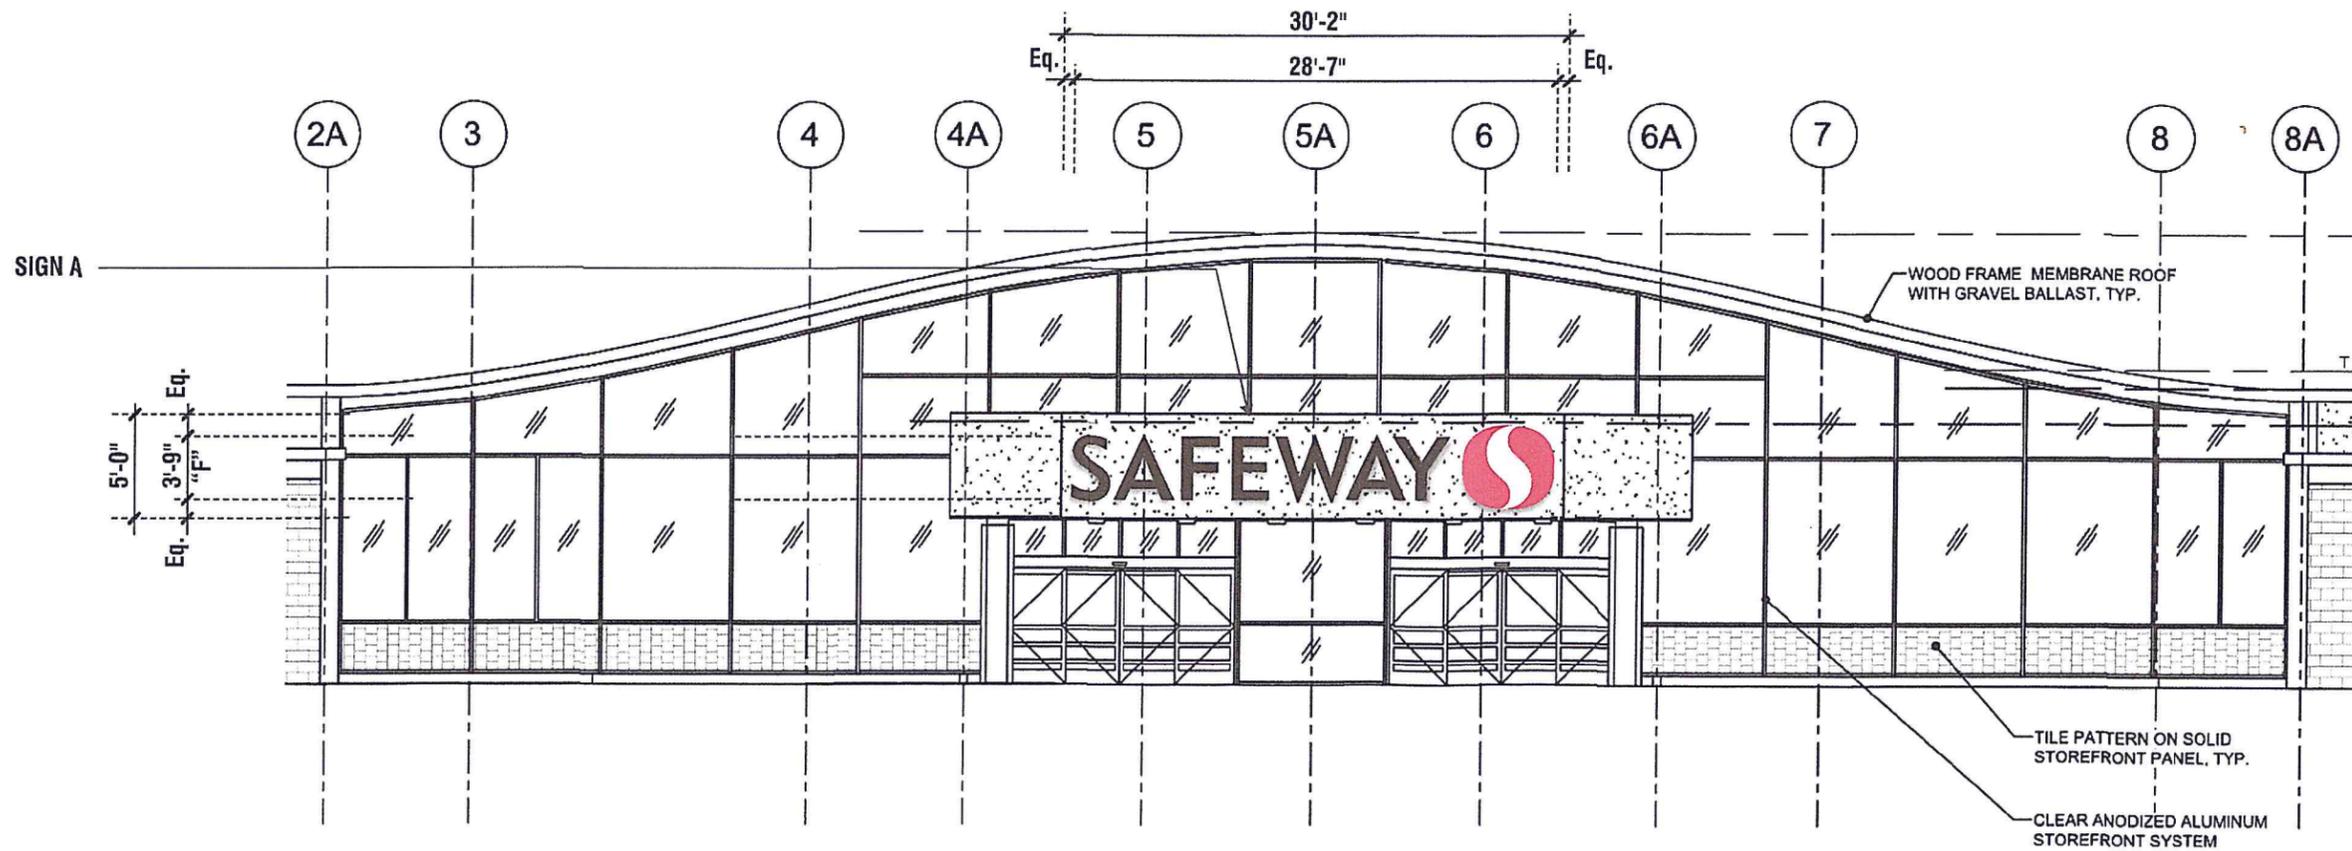

2 PARTIAL FRONT ELEVATION
SCALE: 3/32" = 1'-0"

superior
electrical advertising

1700 West Anaheim Street
Long Beach, California
90813-1195
Phone: 562.495.3808
Facsimile: 562.435.1867
www.superiorsigns.com

Project:
Safeway
Store # 676

Address:
1500 Solano Ave.
Albany, CA 94706

Account Manager:
Tim Pitts

Designer:
Claudio Fuentes 3.50

Scale: **AS NOTED**

Design No.: **15-02-8838-05**

Date: **02.05.15**

Reg. No.:

Revisions:
R1 02-26-15 mdm (1.5) add info
R2 03-30-15 KF (4.0) add info,
square footage and signs C & D
R03 JV 03/31/15 (1.50) add
sign calculations
R04 JV 04/01/15 (1.50) resize Sign A;
add Sign D options
R05 JV 04/07/15 (1.00) revert Sign A
to 45"; Option 3 for Sign D

APPROVALS	
FOR JOB CHECK	DATE
Acct. Mgr.	
FOR CONSTRUCTION	DATE
Acct. Mgr.	
Design	
Production	
FOR INSTALL ONLY	DATE
Acct. Mgr.	

Page: 03 Of: 12

This is an original unpublished drawing created by Superior Electrical Advertising, Inc. It is submitted for your approval. It is not to be shown to anyone outside of your organization, nor is it to be reproduced, copied or exhibited in any fashion. The changing of colors, sizes, materials or illumination method does not alter the design. Ownership of this design is held by Superior Electrical Advertising, Inc. Authorization to use this design in any fashion must be obtained in writing from Superior Electrical Advertising, Inc. © SEA 2015


Note: The Colors depicted here are a graphic representation. Actual colors may vary. See color specifications.



EXISTING CHANNEL LETTERS
TO BE REMOVED AND DISCARDED

NOTE: DIMS LISTED
PER JOB CHECK

1 FRONT ELEVATION- EXISTING CONDITIONS
SCALE: NTS

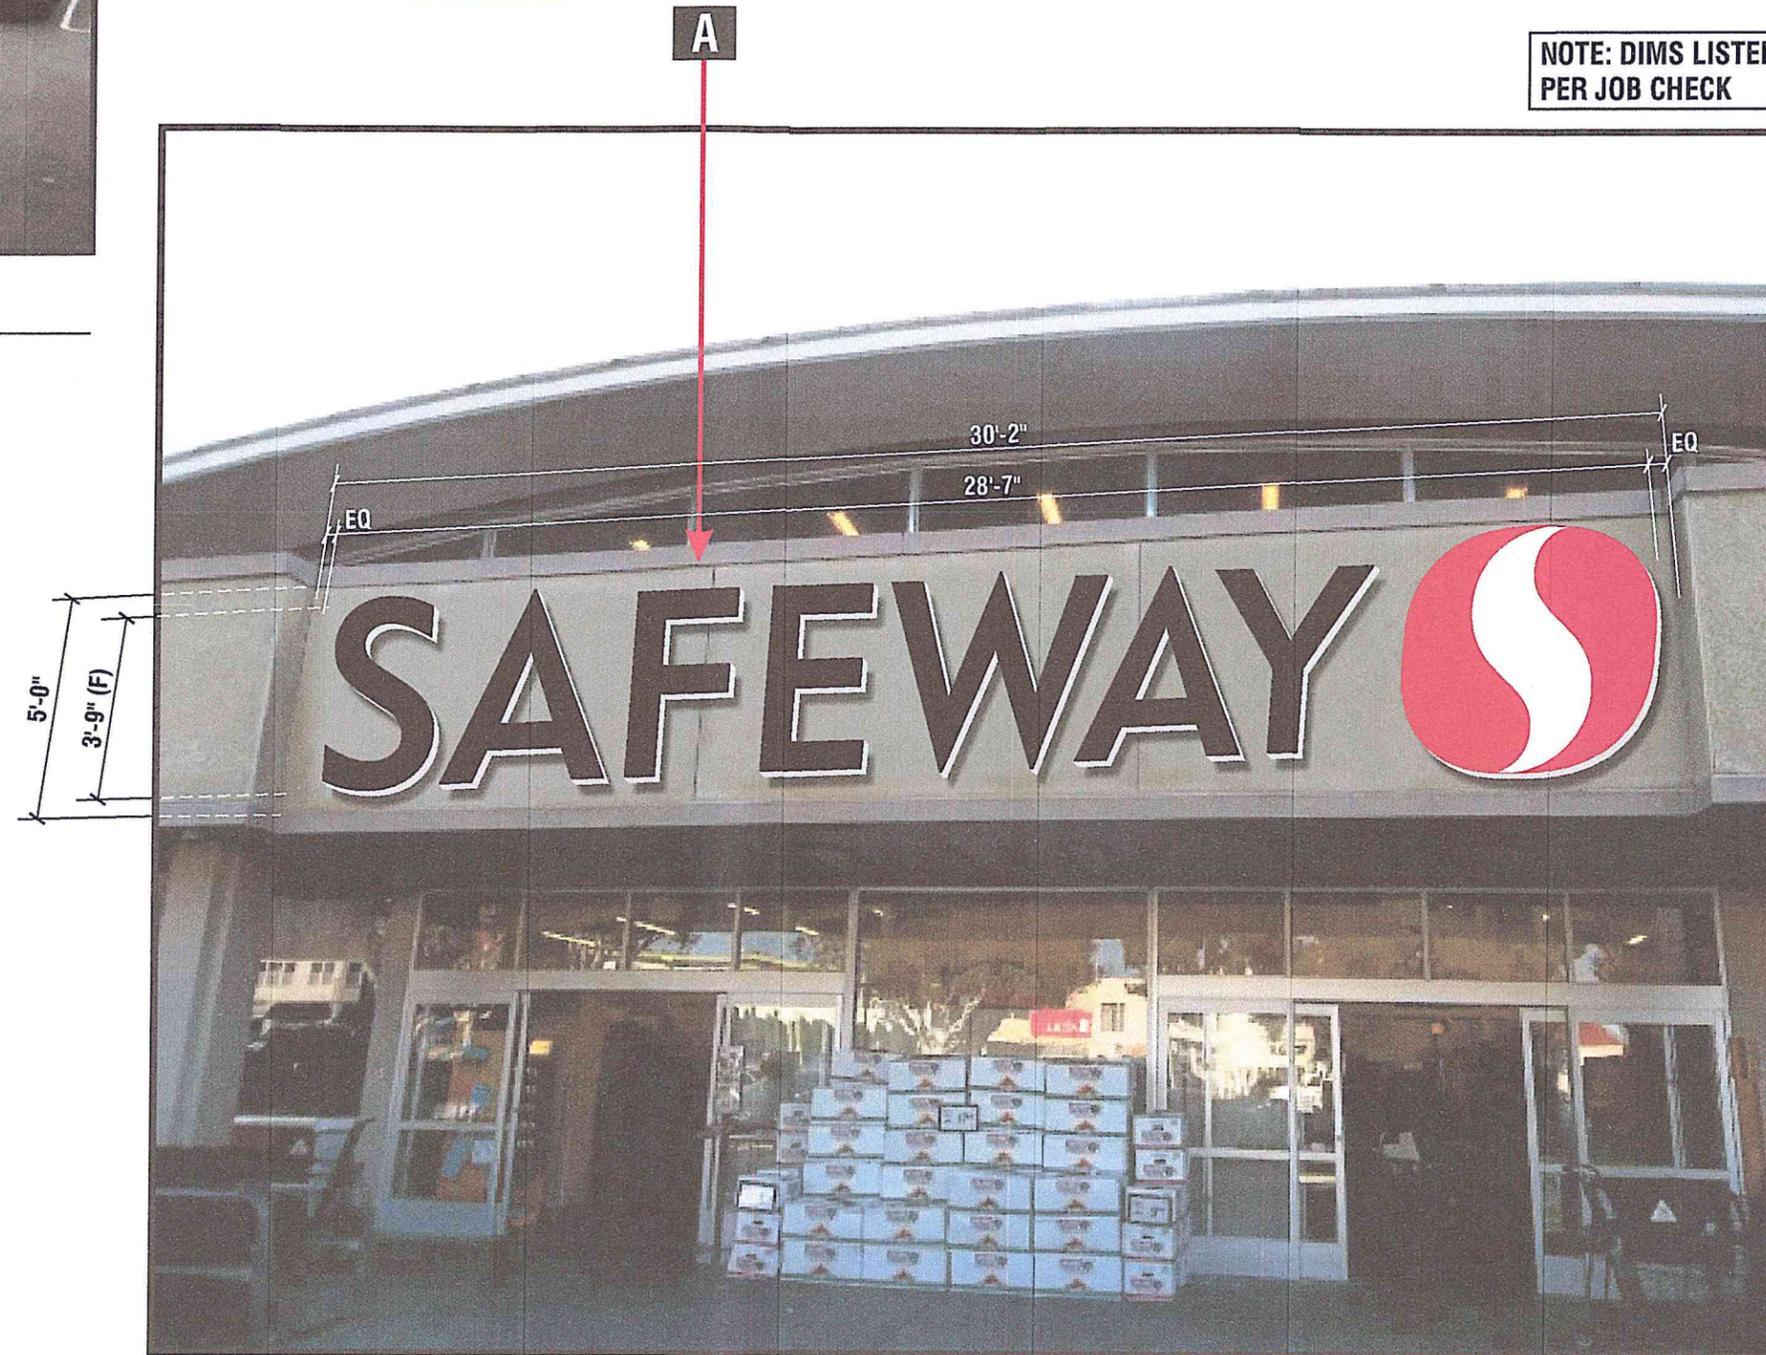

2 FRONT ELEVATION- PROPOSED EXISTING REVERSE CHANNEL LETTERS
APPROX. SCALE: 1/4" = 1'-0"

superior
electrical advertising

1700 West Anaheim Street
Long Beach, California
90813-1195
Phone: 562.495.3808
Facsimile: 562.435.1867
www.superiorsigns.com

Project:
Safeway
Store # 676

Address:
1500 Solano Ave.
Albany, CA 94706

Account Manager:
Tim Pitts

Designer:
Claudio Fuentes 3.50

Scale: **AS NOTED**

Design No.: **15-02-8838-05**

Date: **02.05.15**


Reg. No.:

- Revisions:
- R1 02-26-15 mdm (1.5) add info
 - R2 03-30-15 KF (4.0) add info, square footage and signs C & D
 - R03 JV 03/31/15 (1.50) add sign calculations
 - R04 JV 04/01/15 (1.50) resize Sign A; add Sign D options
 - R05 JV 04/07/15 (1.00) revert Sign A to 45"; Option 3 for Sign D

• APPROVALS •	
FOR JOB CHECK	DATE
Acct. Mgr.	
FOR CONSTRUCTION	DATE
Acct. Mgr.	
Design	
Production	
FOR INSTALL ONLY	DATE
Acct. Mgr.	
Page: 04	Of: 12

This is an original unpublished drawing created by Superior Electrical Advertising, Inc. It is submitted for your approval. It is not to be shown to anyone outside of your organization, nor is it to be reproduced, copied or exhibited in any fashion. The changing of colors, sizes, materials or illumination method does not alter the design. Ownership of this design is held by Superior Electrical Advertising, Inc. Authorization to use this design in any fashion must be obtained in writing from Superior Electrical Advertising, Inc. © SEA 2015

Note: The Colors depicted here are a graphic representation. Actual colors may vary. See color specifications.

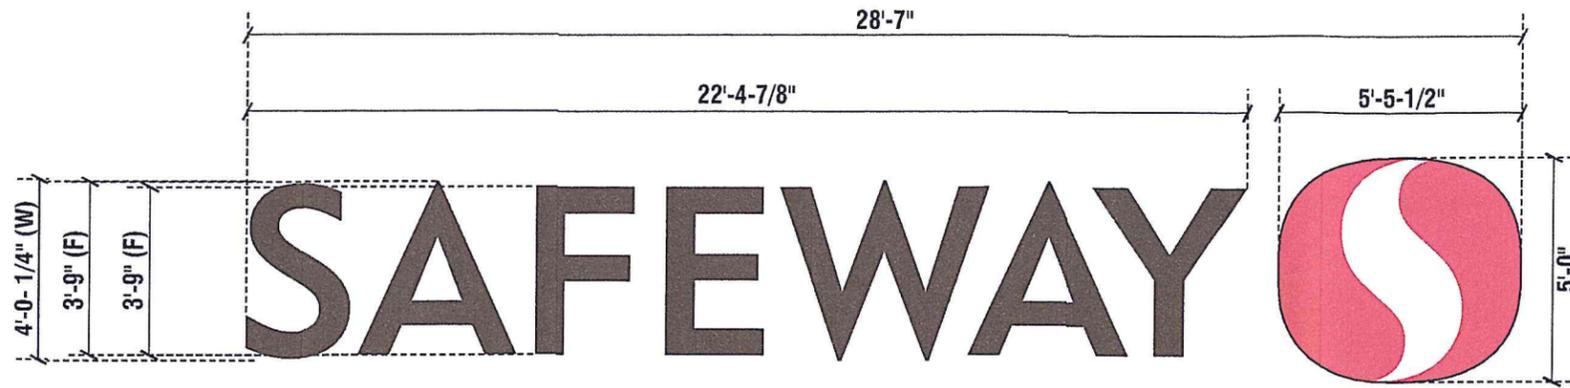

SAF-45-LOCK-LED

3/8" RIV-NUTS FOR ALL THREAD BOLTS

A SIGN ELEVATION / REVERSE HALO ILLUMINATED LETTERS AND FACE LIT CHANNEL LOGO PLAQUE 142.92 SQ. FT.
 QUANTITY : ONE (1) SET REQUIRED SCALE: 1/4" = 1'-0"

SPECIFICATIONS:

LETTERS (SAFEWAY): REVERSE HALO ILLUMINATED CHANNEL LETTERS
FACES: .125" ALUMINUM WITH POWDER COATED BLACK (UBS8-C000) BLACK GLOSS FINISH
RETURNS: 4 1/2" DEEP X .063" ALUMINUM WITH POWDER COATED BLACK (UBS8-C000) GLOSS FINISH
BACKS: CLEAR LEXAN FOR HALO LIGHTING
SPACERS: 1 1/2" SPACERS PAINTED OFF WHITE
ILLUMINATION: "INSEM SSLIGHT-KPL" WHITE LEDS WITH REMOTE POWER SUPPLIES

NOTE:
 THESE APPLICATIONS FOR BUILDING EXTERIOR SIGNAGE FOR 10' APPLICATIONS AND ABOVE

SPECIFICATIONS:

LOGO CHANNEL PLAQUE: INTERNALLY ILLUMINATED CHANNEL PLAQUE
FACE: WHITE LEXAN WITH 3M #3630-53 CARDINAL RED TRANSLUCENT VINYL OVERLAY. WEDED OUT FOR SHOW THRU WHITE "S"
RETURNS: 1/2" LIP X 6" DEEP ALUMINUM EXTRUSION WITH POWDER COATED REGAL RED (PRS8-C0008) GLOSS FINISH
ILLUMINATION: "INSEM SSLIGHT-KPL" WHITE LEDS WITH REMOTE POWER SUPPLIES BEHIND WALL

NOTE: OK PER JOB CHECK

Note to All Contractors

120 Sign Voltage

This sign is intended to be installed in accordance with the requirements of Article 600 of the National Electrical Code and/or other applicable local codes. This includes proper grounding and bonding of the sign. All wall penetrations to be sealed with UL Listed silicone sealant.

superior
 electrical advertising
 1700 West Anaheim Street
 Long Beach, California
 90813-1195
 Phone: 562.495.3808
 Facsimile: 562.435.1867
 www.superiorsigns.com

Project:
Safeway
Store # 676

Address:
1500 Solano Ave.
Albany, CA 94706

Account Manager:
Tim Pitts

Designer:
Claudio Fuentes 3.50

Scale: **AS NOTED**

Design No.: **15-02-8838-05**

Date: **02.05.15**

Reg. No.:

Revisions:
 R1 02-26-15 mdm (1.5) add info
 R2 03-30-15 KF (4.0) add info, square footage and signs C & D
 R03 JV 03/31/15 (1.50) add sign calculations
 R04 JV 04/01/15 (1.50) resize Sign A; add Sign D options
 R05 JV 04/07/15 (1.00) revert Sign A to 45"; Option 3 for Sign D

• APPROVALS •

FOR JOB CHECK DATE

Acct. Mgr.

FOR CONSTRUCTION DATE

Acct. Mgr.

Design

Production

FOR INSTALL ONLY DATE


Acct. Mgr.

Page: **05** Of: **12**

This is an original unpublished drawing created by Superior Electrical Advertising, Inc. It is submitted for your approval. It is not to be shown to anyone outside of your organization, nor is it to be reproduced, copied or exhibited in any fashion. The changing of colors, sizes, materials or illumination method does not alter the design. Ownership of this design is held by Superior Electrical Advertising, Inc. Authorization to use this design in any fashion must be obtained in writing from Superior Electrical Advertising, Inc.

© SEA 2015

Note: The Colors depicted here are a graphic representation. Actual colors may vary. See color specifications.

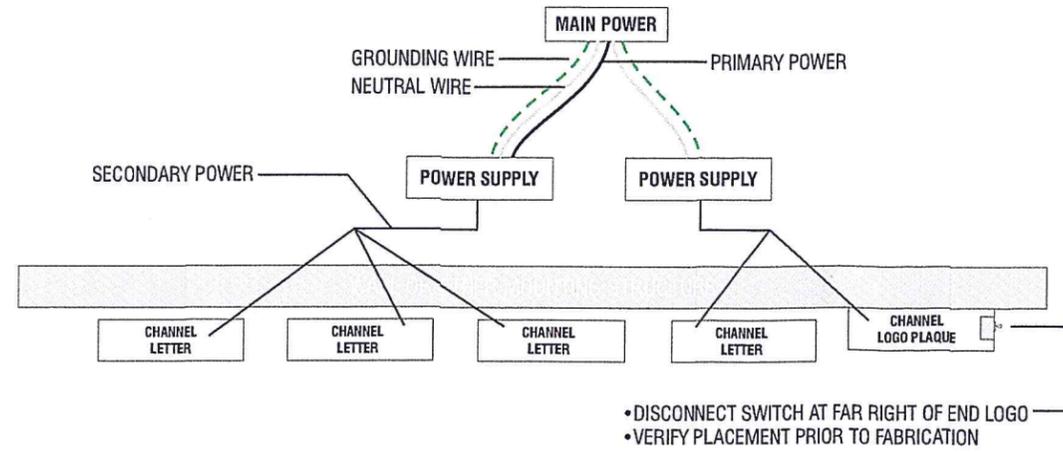

3 LETTERS & LOGO PLAQUE LAYOUT - PLAN VIEW
SCALE: NTS


Note to All Contractors

120 Sign Voltage


This sign is intended to be installed in accordance with the requirements of Article 600 of the National Electrical Code and/or other applicable local codes. This includes proper grounding and bonding of the sign. All wall penetrations to be sealed with UL Listed silicone sealant.

PLEASE REFER TO THE NUMBERED ITEMS BELOW FOR INCORPORATED INSTALL INSTRUCTIONS. LISTED INSTRUCTIONS TO BE FOUND WITH ACTUAL SIGNAGE (NUMBERED ITEMS CORRESPOND TO SECTION DETAIL)

ITEM #	DESCRIPTION
1	CHANNEL LETTERS
2	DISCONNECT SWITCH
3	THREADED NIPPLE AND COUPLING (FLEX CONNECTOR)
4	CLASS 2 LOW VOLTAGE WIRING (NO CONDUIT REQUIRED)
5	POWER SUPPLY
6	FLEX (FLEXIBLE CONDUIT) / LIQUID TIGHT CONNECTIONS

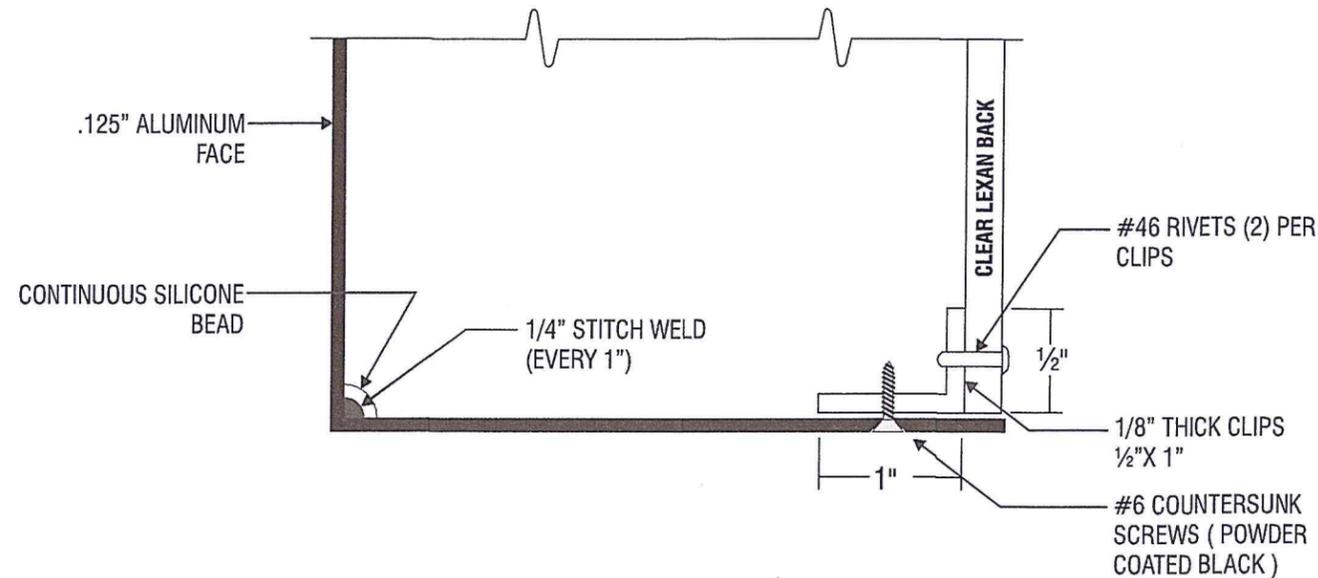

2 TYPICAL LETTER BOTTOM DETAIL
SCALE: NTS

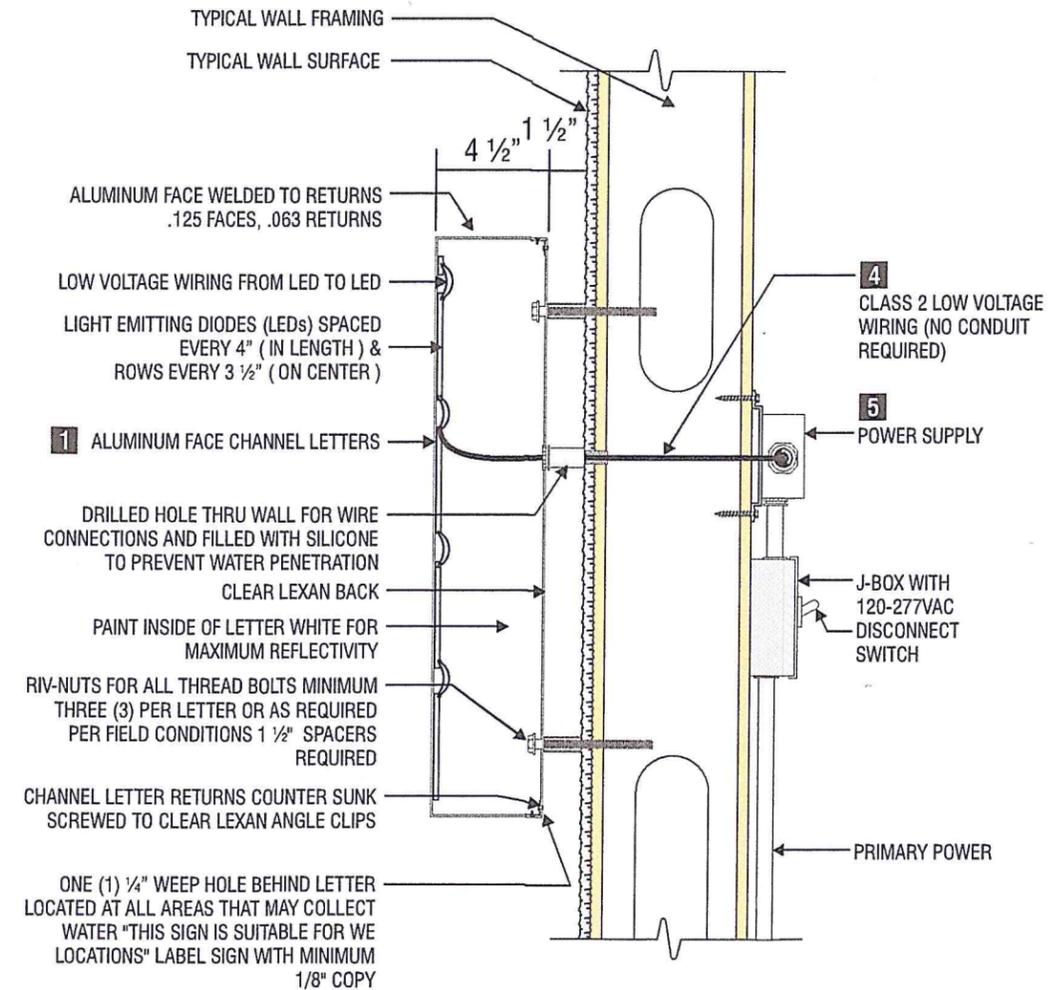

1 TYPICAL (SAFEWAY) LETTER SECTION DETAIL
SCALE: NTS

superior
electrical advertising

1700 West Anaheim Street
Long Beach, California
90813-1195
Phone: 562.495.3808
Facsimile: 562.435.1867
www.superiorsigns.com

Project:
Safeway
Store # 676

Address:
1500 Solano Ave.
Albany, CA 94706

Account Manager:
Tim Pitts

Designer:
Claudio Fuentes 3.50

Scale: **AS NOTED**

Design No.: **15-02-8838-05**

Date: **02.05.15**

Reg. No.:

Revisions:
R1 02-26-15 m dm (1.5) add info
R2 03-30-15 KF (4.0) add info, square footage and signs C & D
R03 JV 03/31/15 (1.50) add sign calculations
R04 JV 04/01/15 (1.50) resize Sign A; add Sign D options
R05 JV 04/07/15 (1.00) revert Sign A to 45"; Option 3 for Sign D

• APPROVALS •

FOR JOB CHECK	DATE
Acct. Mgr.	
FOR CONSTRUCTION	DATE
Acct. Mgr.	
Design	
Production	
FOR INSTALL ONLY	DATE
Acct. Mgr.	

Page: 06 Of: 12

This is an original unpublished drawing created by Superior Electrical Advertising, Inc. It is submitted for your approval. It is not to be shown to anyone outside of your organization, nor is it to be reproduced, copied or exhibited in any fashion. The changing of colors, sizes, materials or illumination method does not alter the design. Ownership of this design is held by Superior Electrical Advertising, Inc. Authorization to use this design in any fashion must be obtained in writing from Superior Electrical Advertising, Inc.
© SEA 2015
Note: The Colors depicted here are a graphic representation. Actual colors may vary. See color specifications.



EXISTING FACES
TO BE REMOVED AND DISCARDED
AND REPLACE NEW FACES

B

1 FRONT ELEVATION- EXISTING CONDITIONS
SCALE: NTS



2 FRONT ELEVATION- PROPOSED REPLACENT FACE
APPROX. SCALE: 1/2" = 1'-0"



superior
electrical advertising
1700 West Anaheim Street
Long Beach, California
90813-1195
Phone: 562.495.3808
Facsimile: 562.435.1867
www.superiorsigns.com

Project:
Safeway
Store # 676

Address:
1500 Solano Ave.
Albany, CA 94706

Account Manager:
Tim Pitts

Designer:
Claudio Fuentes 3.50

Scale: **AS NOTED**

Design No.: **15-02-8838-05**

Date: **02.05.15**

Reg. No.:

Revisions:
R1 02-26-15 mdm (1.5) add info
R2 03-30-15 KF (4.0) add info,
square footage and signs C & D
R03 JV 03/31/15 (1.50) add
sign calculations
R04 JV 04/01/15 (1.50) resize Sign A;
add Sign D options
R05 JV 04/07/15 (1.00) revert Sign A
to 45"; Option 3 for Sign D

• APPROVALS •

FOR JOB CHECK DATE

Acct. Mgr.

FOR CONSTRUCTION DATE

Acct. Mgr.

Design

Production


FOR INSTALL ONLY DATE

Acct. Mgr.

Page: **07** Of: **12**

This is an original unpublished drawing created by Superior Electrical Advertising, Inc. It is submitted for your approval. It is not to be shown to anyone outside of your organization, nor is it to be reproduced, copied or exhibited in any fashion. The changing of colors, sizes, materials or illumination method does not alter the design. Ownership of this design is held by Superior Electrical Advertising, Inc. Authorization to use this design in any fashion must be obtained in writing from Superior Electrical Advertising, Inc.
© SEA 2015

Note: The Colors depicted here are a graphic representation. Actual colors may vary. See color specifications.

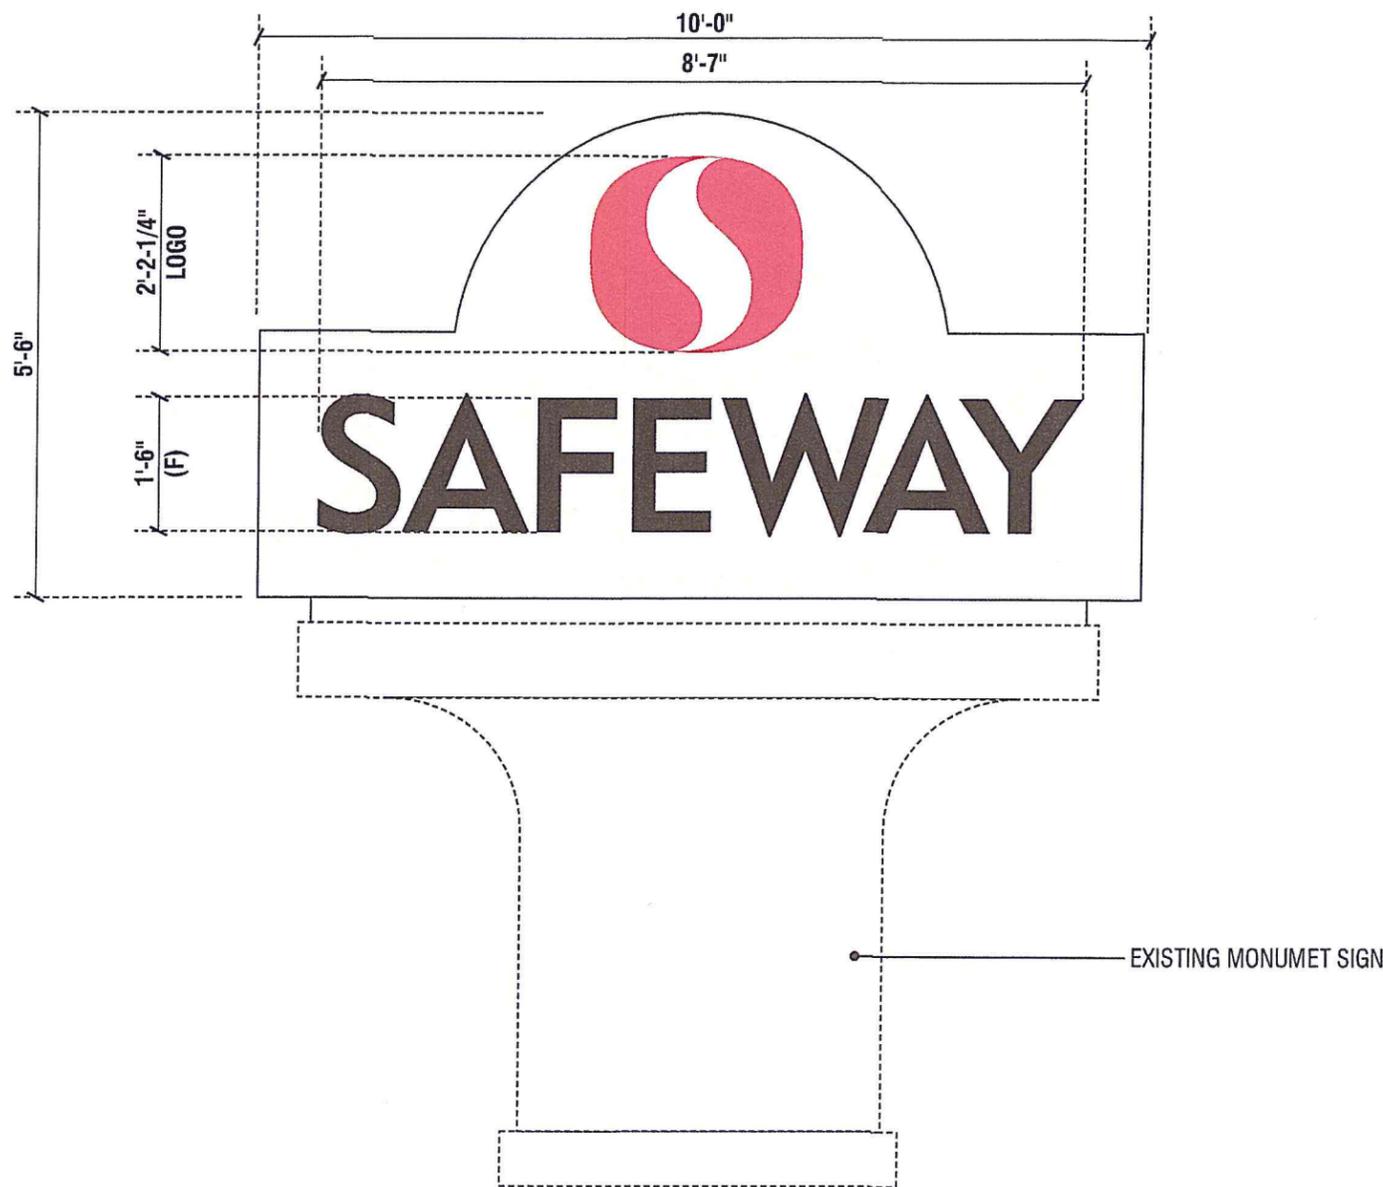

B

SIGN ELEVATION / NEW REPLACEMENT FACES

QUANTITY: TWO (2) FACES REQUIRED

SCALE: 1/2" = 1'-0"

SPECIFICATIONS:

FACE: 0.125" THICK ALUMINUM PANEL TO BE ROUTED & PAINTED TO MATCH EXISTING MONUMENT SIGN

LOGO: 3/4" THICK CLEAR ACRYLIC PUSH THRU APPLY 3M# 3630-20 WHITE VINYL FIRST SURFACE, AND SECOND SURFACE 3M# 3635-30 WHITE DIFFUSER FIRST SURFACE OVERLAY WITH 3M# 3630-53 CARDINAL RED VINYL

SAFEWAY: 3/4" THICK CLEAR ACRYLIC PUSH THRU APPLIED 3M#3630-22 BLACK VINYL, SECOND SURFACE 3M# 3635-30 WHITE DIFFUSER

ILLUMINATION: TO REMAIN AS IS

NOTE: OK PER JOB CHECK

superior
electrical advertising
1700 West Anaheim Street
Long Beach, California
90813-1195
Phone: 562.495.3808
Facsimile: 562.435.1867
www.superiorsigns.com

Project:
Safeway
Store # 676

Address:
1500 Solano Ave.
Albany, CA 94706

Account Manager:
Tim Pitts

Designer:
Claudio Fuentes 3.50

Scale: **AS NOTED**

Design No.: **15-02-8838-05**

Date: **02.05.15**

Reg. No.:

Revisions:
R1 02-26-15 mdm (1.5) add info
R2 03-30-15 KF (4.0) add info, square footage and signs C & D
R03 JV 03/31/15 (1.50) add sign calculations
R04 JV 04/01/15 (1.50) resize Sign A; add Sign D options
R05 JV 04/07/15 (1.00) revert Sign A to 45"; Option 3 for Sign D

• APPROVALS •

FOR JOB CHECK DATE

Acct. Mgr.

FOR CONSTRUCTION DATE

Acct. Mgr.

Design

Production

FOR INSTALL ONLY DATE

Acct. Mgr.

Page: **08** Of: **12**

This is an original unpublished drawing created by Superior Electrical Advertising, Inc. It is submitted for your approval. It is not to be shown to anyone outside of your organization, nor is it to be reproduced, copied or exhibited in any fashion. The changing of colors, sizes, materials or illumination method does not alter the design. Ownership of this design is held by Superior Electrical Advertising, Inc. Authorization to use this design in any fashion must be obtained in writing from Superior Electrical Advertising, Inc.


© SEA 2015

Note: The Colors depicted here are a graphic representation. Actual colors may vary. See color specifications.



EXISTING CHANNEL LOGO
TO BE REMOVED AND DISCARDED
62" x 76" = 32.722 sq. ft.

1 FRONT ELEVATION- EXISTING CONDITIONS
SCALE: NTS

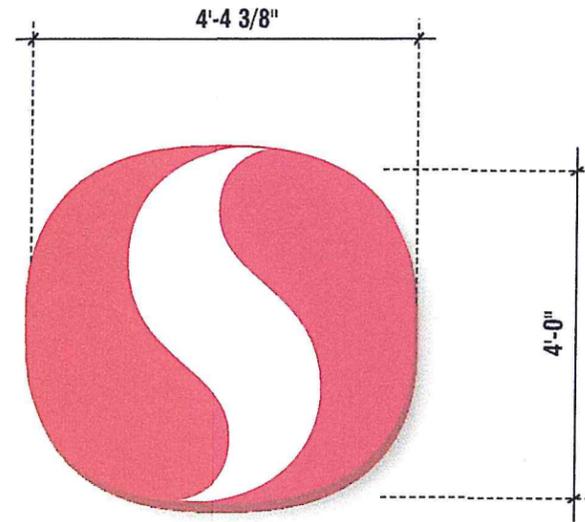

SAF-45-LOCK-LED 3/8" RIV-NUTS FOR ALL THREAD BOLTS

C SIGN ELEVATION / FACE LIT CHANNEL LOGO 17.43 SQ. FT.
QUANTITY : ONE (1) SET REQUIRED SCALE: 1/2" = 1'-0"

SPECIFICATIONS:

LOGO CHANNEL PLAQUE: INTERNALLY ILLUMINATED CHANNEL PLAQUE
FACE: WHITE LEXAN WITH 3M #3630-53 CARDINAL RED TRANSLUCENT VINYL OVERLAY. WEDED OUT FOR SHOW THRU WHITE "S"
RETURNS: 1/2" LIP X 6" DEEP ALUMINUM EXTRUSION WITH POWDER COATED REGAL RED (PRS8-C0008) GLOSS FINISH
ILLUMINATION: "INSEM SSLIGHT-KPL" WHITE LEDS WITH REMOTE POWER SUPPLIES BEHIND WALL

NOTE: OK PER JOB CHECK

NOTE:
THESE APPLICATIONS FOR BUILDING EXTERIOR SIGNAGE FOR 10' APPLICATIONS AND ABOVE

Note to All Contractors

120 Sign Voltage
This sign is intended to be installed in accordance with the requirements of Article 600 of the National Electrical Code and/or other applicable local codes. This includes proper grounding and bonding of the sign. All wall penetrations to be sealed with UL Listed silicone sealant.



2 FRONT ELEVATION - PROPOSED
SCALE: NTS

superior
electrical advertising
1700 West Anaheim Street
Long Beach, California
90813-1195
Phone: 562.495.3808
Facsimile: 562.435.1867
www.superiorsigns.com

Project:
Safeway
Store # 676

Address:
1500 Solano Ave.
Albany, CA 94706

Account Manager:
Tim Pitts

Designer:
Claudio Fuentes 3.50

Scale: **AS NOTED**

Design No.: **15-02-8838-05**

Date: **02.05.15**

Reg. No.:

Revisions:
R1 02-26-15 mdm (1.5) add info
R2 03-30-15 KF (4.0) add info, square footage and signs C & D
R03 JV 03/31/15 (1.50) add sign calculations
R04 JV 04/01/15 (1.50) resize Sign A; add Sign D options
R05 JV 04/07/15 (1.00) revert Sign A to 45"; Option 3 for Sign D

• APPROVALS •

FOR JOB CHECK DATE

Acct. Mgr.

FOR CONSTRUCTION DATE

Acct. Mgr.

Design

Production

FOR INSTALL ONLY DATE

Acct. Mgr.

Page: 09 Of: 12

This is an original unpublished drawing created by Superior Electrical Advertising, Inc. It is submitted for your approval. It is not to be shown to anyone outside of your organization, nor is it to be reproduced, copied or exhibited in any fashion. The changing of colors, sizes, materials or illumination method does not alter the design. Ownership of this design is held by Superior Electrical Advertising, Inc. Authorization to use this design in any fashion must be obtained in writing from Superior Electrical Advertising, Inc.

© SEA 2015
Note: The Colors depicted here are a graphic representation. Actual colors may vary. See color specifications.


PLEASE REFER TO THE NUMBERED ITEMS BELOW FOR INCORPORATED INSTALL INSTRUCTIONS. LISTED INSTRUCTIONS TO BE FOUND WITH ACTUAL SIGNAGE (NUMBERED ITEMS CORRESPOND TO SECTION DETAIL)

ITEM #	DESCRIPTION
1	CHANNEL PLAQUE
2	DISCONNECT SWITCH
3	THREADED NIPPLE AND COUPLING (FLEX CONNECTOR)
4	CLASS 2 LOW VOLTAGE WIRING (NO CONDUIT REQUIRED)
5	POWER SUPPLY
6	FLEX (FLEXIBLE CONDUIT) / LIQUID TIGHT CONNECTIONS


Note to All Contractors

120 Sign Voltage


This sign is intended to be installed in accordance with the requirements of Article 600 of the National Electrical Code and/or other applicable local codes. This includes proper grounding and bonding of the sign. All wall penetrations to be sealed with UL Listed silicone sealant.

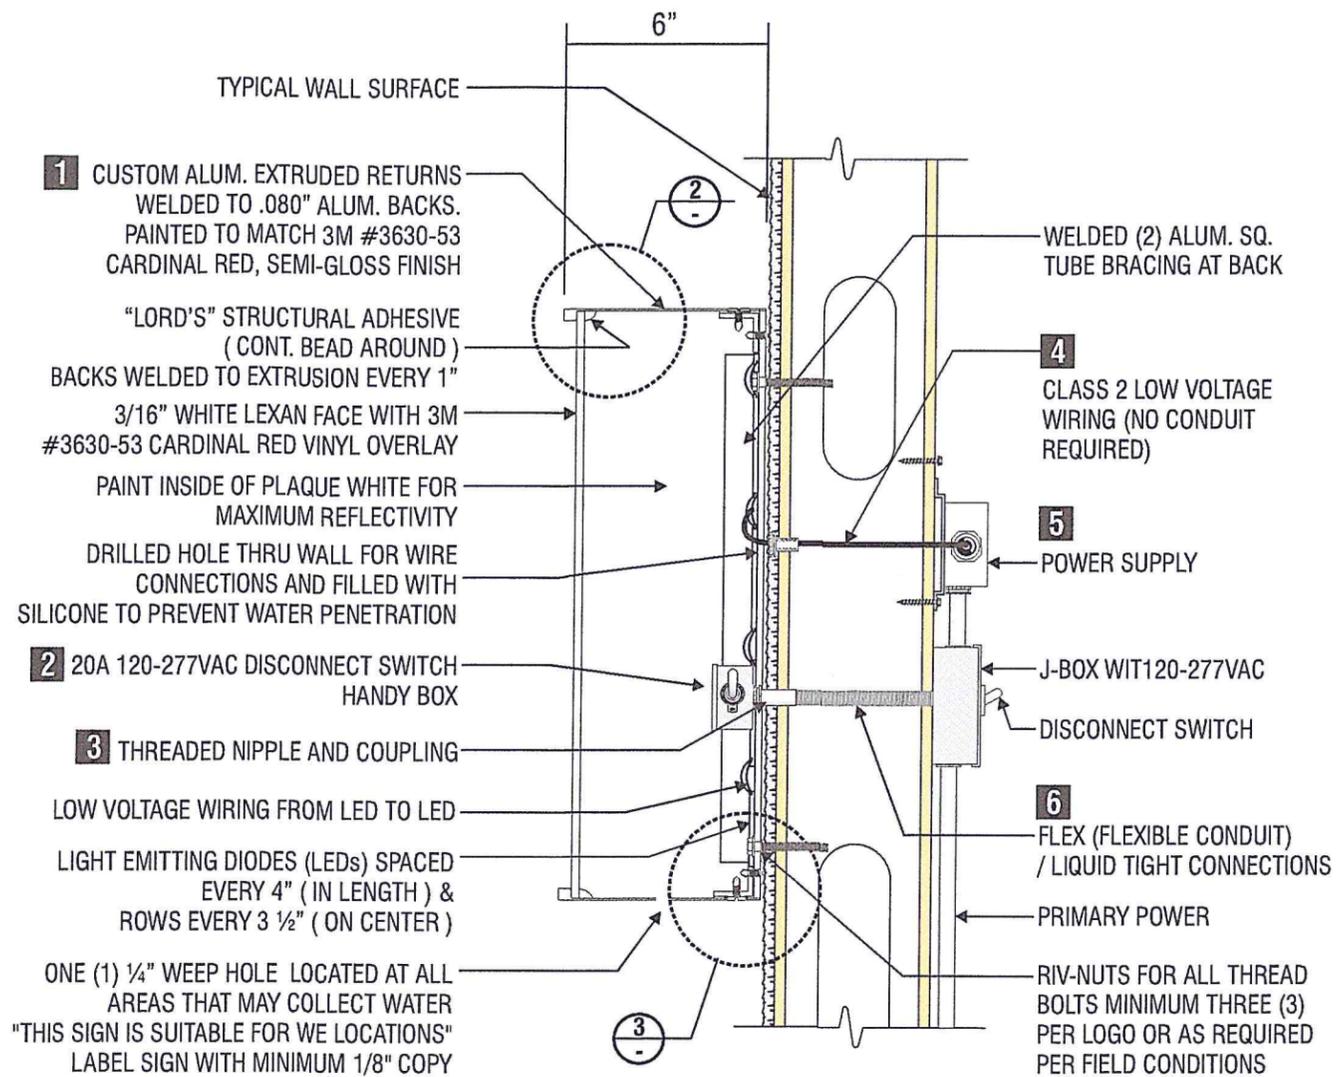

1 "SAFEWAY" LOGO CHANNEL PLAQUE SECTION DETAIL
SCALE: NTS

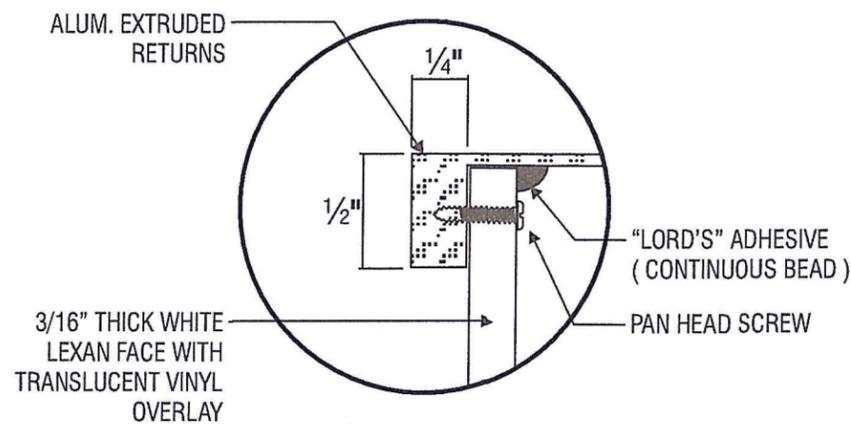

2 FRONT EDGE DETAIL
SCALE: NTS

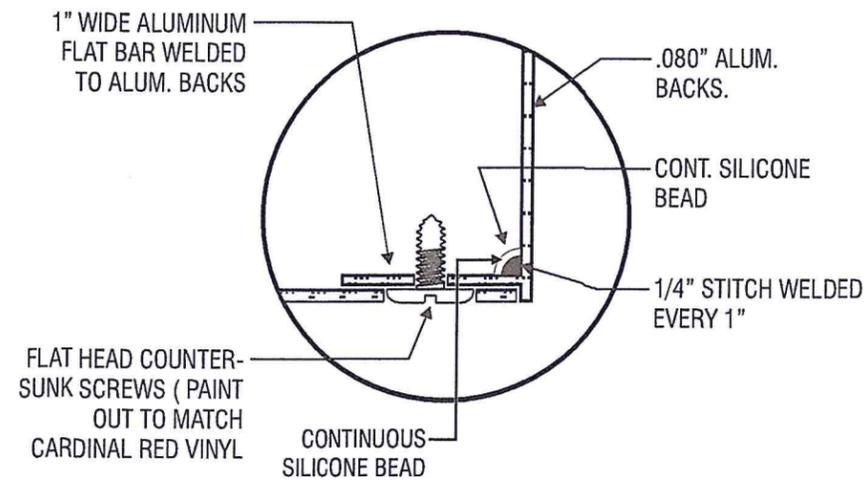

3 CHANNEL PLAQUE BACKS DETAIL
SCALE: NTS

superior
electrical advertising

1700 West Anaheim Street
Long Beach, California
90813-1195
Phone: 562.495.3808
Facsimile: 562.435.1867
www.superiorsigns.com

Project:
Safeway
Store # 676

Address:
1500 Solano Ave.
Albany, CA 94706

Account Manager:
Tim Pitts

Designer:
Claudio Fuentes 3.50

Scale: **AS NOTED**

Design No.: **15-02-8838-05**

Date: **02.05.15**

Reg. No.:

Revisions:
R1 02-26-15 mdm (1.5) add info
R2 03-30-15 KF (4.0) add info, square footage and signs C & D
R03 JV 03/31/15 (1.50) add sign calculations
R04 JV 04/01/15 (1.50) resize Sign A; add Sign D options
R05 JV 04/07/15 (1.00) revert Sign A to 45"; Option 3 for Sign D

APPROVALS

FOR JOB CHECK DATE

Acct. Mgr.

FOR CONSTRUCTION DATE

Acct. Mgr.

Design

Production

FOR INSTALL ONLY DATE


Acct. Mgr.

Page: 10 Of: 12

This is an original unpublished drawing created by Superior Electrical Advertising, Inc. It is submitted for your approval. It is not to be shown to anyone outside of your organization, nor is it to be reproduced, copied or exhibited in any fashion. The changing of colors, sizes, materials or illumination method does not alter the design. Ownership of this design is held by Superior Electrical Advertising, Inc. Authorization to use this design in any fashion must be obtained in writing from Superior Electrical Advertising, Inc.


© SEA 2015

Note: The Colors depicted here are a graphic representation. Actual colors may vary. See color specifications.

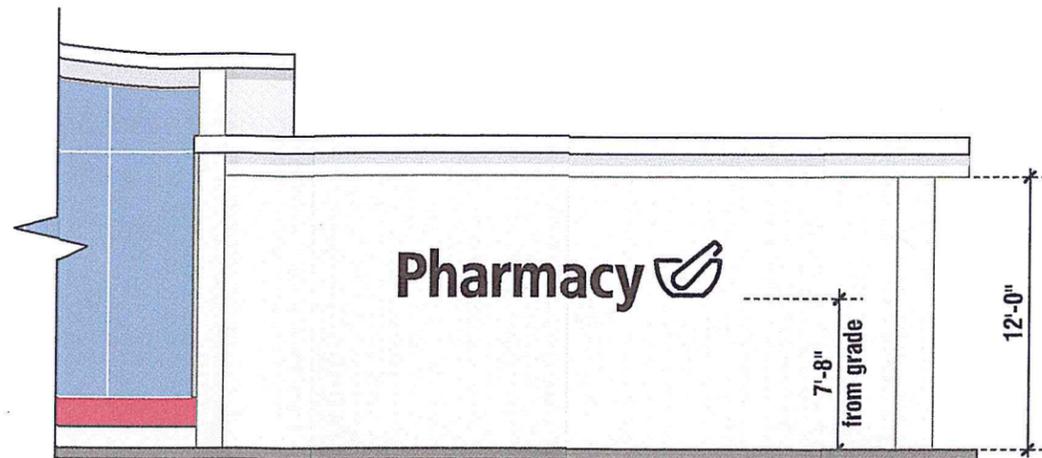

1 FRONT ELEVATION- EXISTING CONDITIONS
SCALE: NTS

2 FRONT ELEVATION-PROPOSED
SCALE: 1/8" = 1'-0"

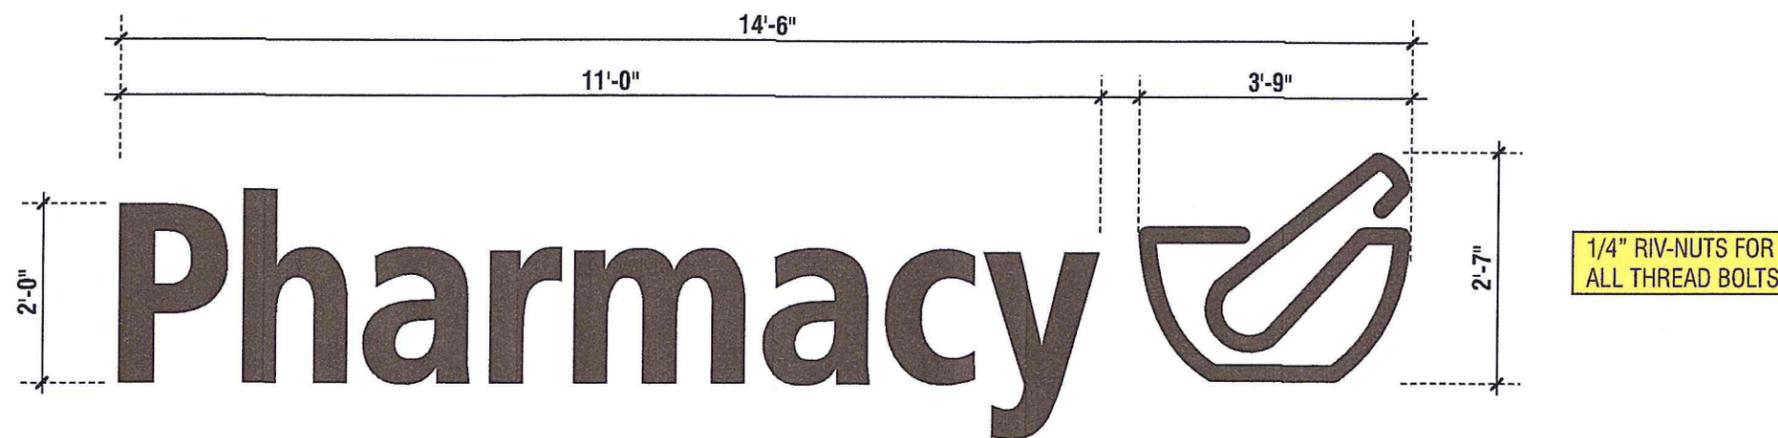

D SIGN ELEVATION / REVERSE HALO ILLUMINATED LETTERS AND CHANNEL LOGO PLAQUE 31.68 SQ. FT.
SCALE: 1/2" = 1'-0"

SPECIFICATIONS:

LETTERS & CHANNEL LOGO PLAQUE:

- REVERSE HALO ILLUMINATED CHANNEL LETTERS & CHANNEL PLAQUE
- FACES:** .125" ALUMINUM WITH POWDER COATED BLACK (UBS8-C000) GLOSS FINISH
- RETURNS:** 3" DEEP X .063" ALUMINUM WITH POWDER COATED BLACK (UBS8-C000) GLOSS FINISH
- BACKS:** CLEAR LEXAN FOR HALO LIGHTING
- SPACERS:** 1 1/2" SPACERS PAINTED OFF WHITE
- ILLUMINATION:** WHITE PERMLIGHT "EL PLATO" / "NITRO TWISTER" 5600-7000k OR APPROVED EQUAL ILLUMINATION WITH REMOTE POWER SUPPLIES

superior
electrical advertising

1700 West Anaheim Street
Long Beach, California
90813-1195
Phone: 562.495.3808
Facsimile: 562.435.1867
www.superiorsigns.com

Project:
Safeway
Store # 676

Address:
1500 Solano Ave.
Albany, CA 94706

Account Manager:
Tim Pitts

Designer:
Claudio Fuentes 3.50

Scale: **AS NOTED**

Design No.: **15-02-8838-05**

Date: **02.05.15**

Reg. No.:

- Revisions:
- R1 02-26-15 mdm (1.5) add info
 - R2 03-30-15 KF (4.0) add info, square footage and signs C & D
 - R03 JV 03/31/15 (1.50) add sign calculations
 - R04 JV 04/01/15 (1.50) resize Sign A; add Sign D options
 - R05 JV 04/07/15 (1.00) revert Sign A to 45"; Option 3 for Sign D

APPROVALS

FOR JOB CHECK DATE

Acct. Mgr.

FOR CONSTRUCTION DATE

Acct. Mgr.

Design

Production

FOR INSTALL ONLY DATE


Acct. Mgr.

Page: 11 Of: 12

This is an original unpublished drawing created by Superior Electrical Advertising, Inc. It is submitted for your approval. It is not to be shown to anyone outside of your organization, nor is it to be reproduced, copied or exhibited in any fashion. The changing of colors, sizes, materials or illumination method does not alter the design. Ownership of this design is held by Superior Electrical Advertising, Inc. Authorization to use this design in any fashion must be obtained in writing from Superior Electrical Advertising, Inc.

© SEA 2015

Note: The Colors depicted here are a graphic representation. Actual colors may vary. See color specifications.

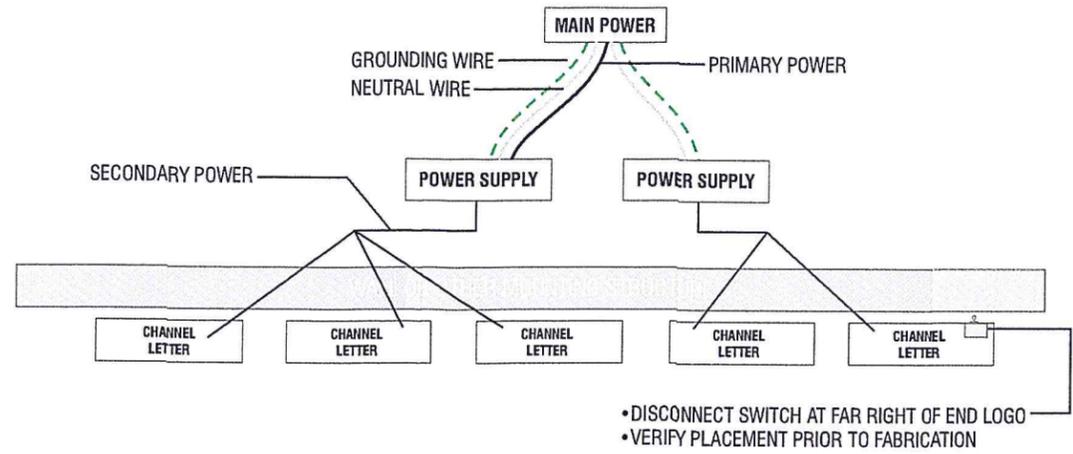


2 LETTERS & LOGO PLAQUE LAYOUT - PLAN VIEW
SCALE: NTS

PLEASE REFER TO THE NUMBERED ITEMS BELOW FOR INCORPORATED INSTALL INSTRUCTIONS. LISTED INSTRUCTIONS TO BE FOUND WITH ACTUAL SIGNAGE (NUMBERED ITEMS CORRESPOND TO SECTION DETAIL)

ITEM #	DESCRIPTION
1	CHANNEL LETTERS
2	DISCONNECT SWITCH
3	THREADED NIPPLE AND COUPLING (FLEX CONNECTOR)
4	CLASS 2 LOW VOLTAGE WIRING (NO CONDUIT REQUIRED)
5	POWER SUPPLY
6	FLEX (FLEXIBLE CONDUIT) / LIQUID TIGHT CONNECTIONS

Note to All Contractors

120 Sign Voltage
This sign is intended to be installed in accordance with the requirements of Article 600 of the National Electrical Code and/or other applicable local codes. This includes proper grounding and bonding of the sign. All wall penetrations to be sealed with UL Listed silicone sealant.

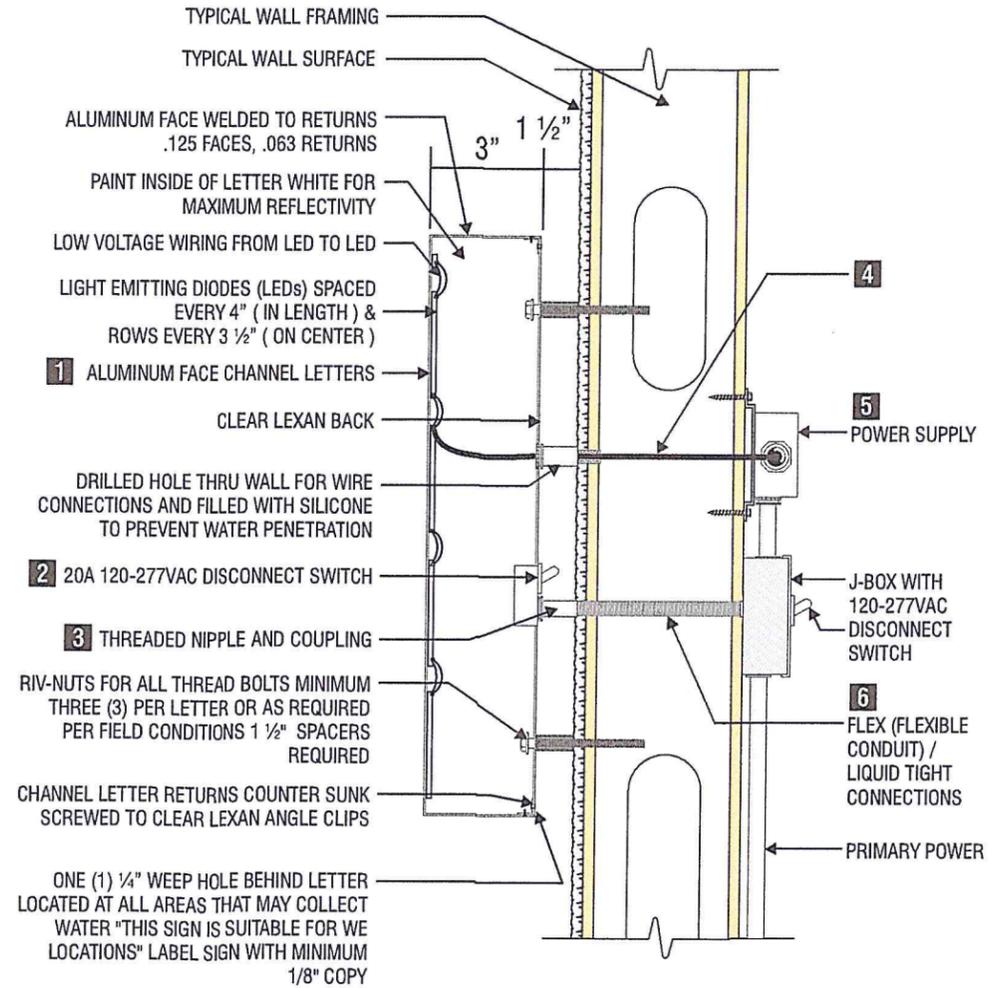

1 TYPICAL LETTER SECTION DETAIL
SCALE: NTS

superior
electrical advertising
1700 West Anaheim Street
Long Beach, California
90813-1195
Phone: 562.495.3808
Facsimile: 562.435.1867
www.superiorsigns.com

Project:
Safeway
Store # 676

Address:
1500 Solano Ave.
Albany, CA 94706

Account Manager:
Tim Pitts
Designer:
Claudio Fuentes 3.50
Scale: **AS NOTED**
Design No.: **15-02-8838-05**
Date: **02.05.15**
Reg. No.:

Revisions:
R1 02-26-15 m dm (1.5) add info
R2 03-30-15 KF (4.0) add info, square footage and signs C & D
R03 JV 03/31/15 (1.50) add sign calculations
R04 JV 04/01/15 (1.50) revert Sign A; add Sign D options
R05 JV 04/07/15 (1.00) revert Sign A to 45"; Option 3 for Sign D

APPROVALS

FOR JOB CHECK	DATE
Acct. Mgr.	
FOR CONSTRUCTION	DATE
Acct. Mgr.	
Design	
Production	
FOR INSTALL ONLY	DATE
Acct. Mgr.	

Page: 12 Of: 12
This is an original unpublished drawing created by Superior Electrical Advertising, Inc. It is submitted for your approval. It is not to be shown to anyone outside of your organization, nor is it to be reproduced, copied or exhibited in any fashion. The changing of colors, sizes, materials or illumination method does not alter the design. Ownership of this design is held by Superior Electrical Advertising, Inc. Authorization to use this design in any fashion must be obtained in writing from Superior Electrical Advertising, Inc.
© SEA 2015
Note: The Colors depicted here are a graphic representation. Actual colors may vary. See color specifications.